

DESCRIPTION	DATUM	BATTEN CENTER DISTANCE TO DATUM	ARBOR CENTER DISTANCE TO DATUM	SET ID#
GP (MAIN VALENCE) NIC	0'-0"	0'-0"	0'-0"	0
GP (MAIN TRAPEZOID) NIC	0'-11"	0'-11"	0'-11"	1
FIXED ELECTRIC #1	2'-0"	2'-0"	2'-0"	2
FIXED ELECTRIC #2	3'-2"	3'-2"	3'-2"	3
ORCHESTRA SHELL #1	3'-9"	3'-9"	3'-9"	4
ORCHESTRA SHELL #2	4'-7"	4'-7"	4'-7"	5
GP (BORDER #1) NIC	6'-0"	6'-0"	6'-0"	6
GP (BORDER #2) NIC	6'-11"	6'-11"	6'-11"	7
FIXED ELECTRIC #3	8'-5"	8'-5"	8'-5"	8
FIXED ELECTRIC #4	9'-7"	9'-7"	9'-7"	9
GP	10'-3"	10'-3"	10'-3"	10
GP	10'-8"	10'-8"	10'-8"	11
GP	11'-5"	11'-5"	11'-5"	12
ORCHESTRA SHELL #3	12'-10"	12'-10"	12'-10"	13
GP (BORDER #3) NIC	14'-2"	14'-2"	14'-2"	14
FIXED ELECTRIC #5	14'-5"	14'-5"	14'-5"	15
GP	15'-5"	15'-5"	15'-5"	16
GP (BORDER #4) NIC	16'-7"	16'-7"	16'-7"	17
GP (CLEGS #1) NIC	19'-8"	19'-8"	19'-8"	18
ORCHESTRA SHELL #4	20'-11"	20'-11"	20'-11"	19
GP (BORDER #5) NIC	22'-0"	22'-0"	22'-0"	20
GP (CLEGS #2) NIC	23'-0"	23'-0"	23'-0"	21
GP (CLEGS #3) NIC	23'-0"	23'-0"	23'-0"	22
GP (CLEGS #4) NIC	23'-0"	23'-0"	23'-0"	23
GP (CLEGS #5) NIC	23'-0"	23'-0"	23'-0"	24
FIXED ELECTRIC #6	24'-4"	24'-4"	24'-4"	25
GP	25'-0"	25'-0"	25'-0"	26
GP	27'-6"	27'-6"	27'-6"	27
GP	29'-0"	29'-0"	29'-0"	28
GP	31'-0"	31'-0"	31'-0"	29
GP (C/C) NIC	31'-6"	31'-6"	31'-6"	30
GP	31'-6"	31'-6"	31'-6"	31
GP	31'-6"	31'-6"	31'-6"	32

2 PLAN AT STAGE LEVEL
3/16" = 1'-0"

1 SECTION AT CENTERLINE
3/16" = 1'-0"

NO. ISSUE
75% CD CHECK SET

DATE
03/08/2015

SOLANO COMMUNITY COLLEGE
BUILDING 1200 THEATER RENOVATION
4000 SUISUN VALLEY ROAD, FAIRFIELD, CA



ARCHITECT / CONSULTANT
The Shalleck Collaborative Inc.
400 Montgomery St., Suite 500
San Francisco, CA 94104
tel 415-956-4100
fax 415-840-0494


APPROVAL
DSA FILE NO: 48-C1
IDENTIFICATION STAMP
DIV. OF THE STATE ARCHITECT
OFFICE OF REGULATION SERVICES
02-113590
AC FLS SS
DATE

LPAS
2484 Natomas Park Drive Suite 100 Sacramento CA 95833
916 443 0335 lpasdesign.com Architecture + Design


ORCHESTRA SHELL PLAN & SECTION

SCCD PROJECT NO: 14-014
LPAS PROJECT NO: 764-0002
DATE: JANUARY 19, 2017
SHEET NO:


PO1.01

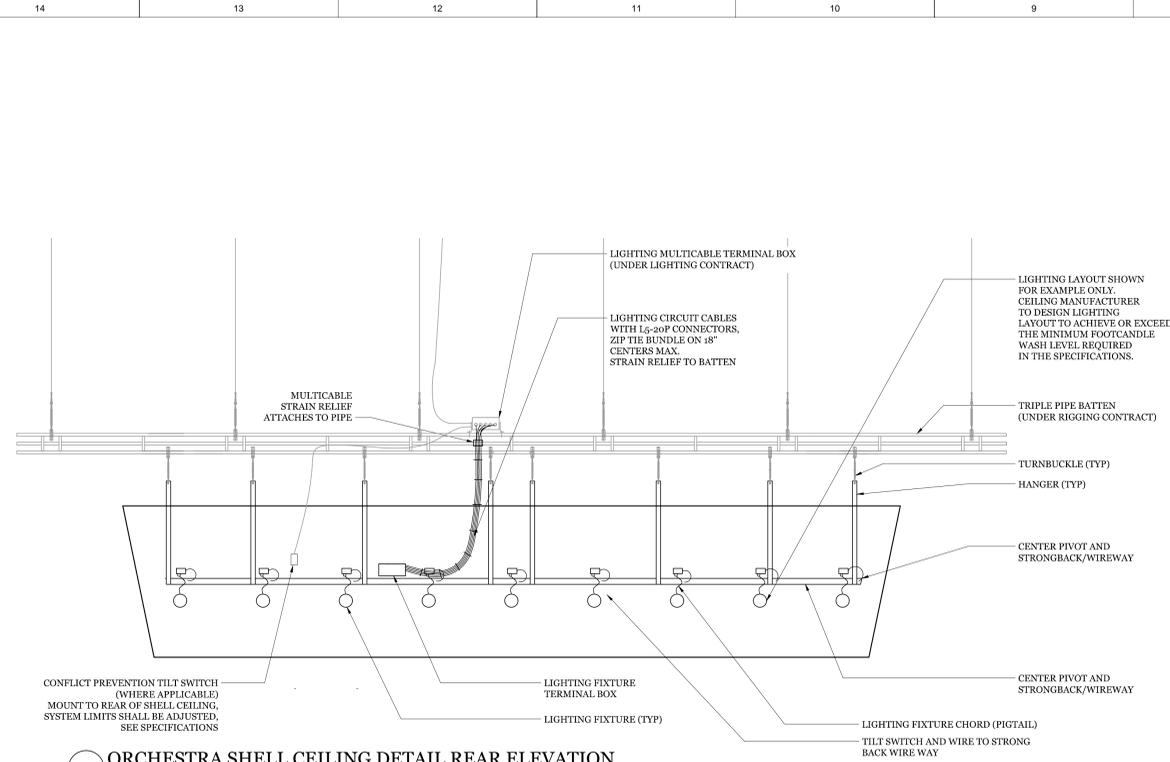


5 ORCHESTRA SHELL CEILING DETAIL REAR ELEVATION
1/4" = 1'-0"

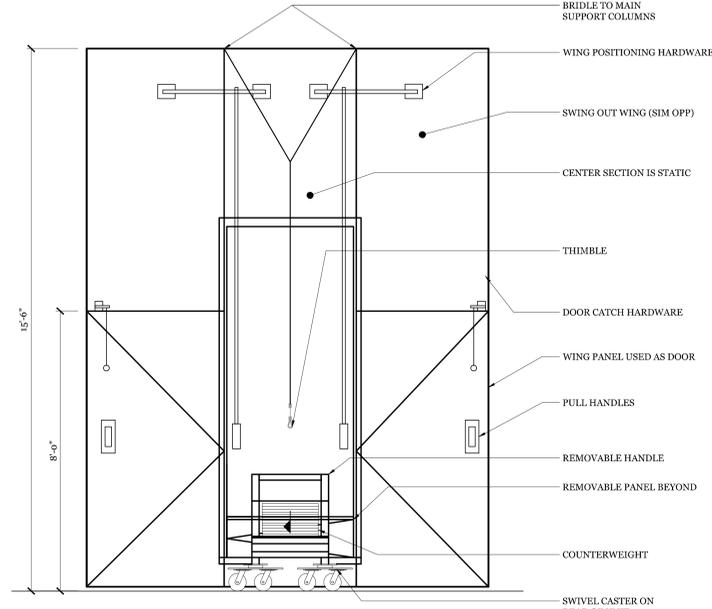


3 ORCHESTRA SHELL REAR ELEVATION
1/2" = 1'-0"

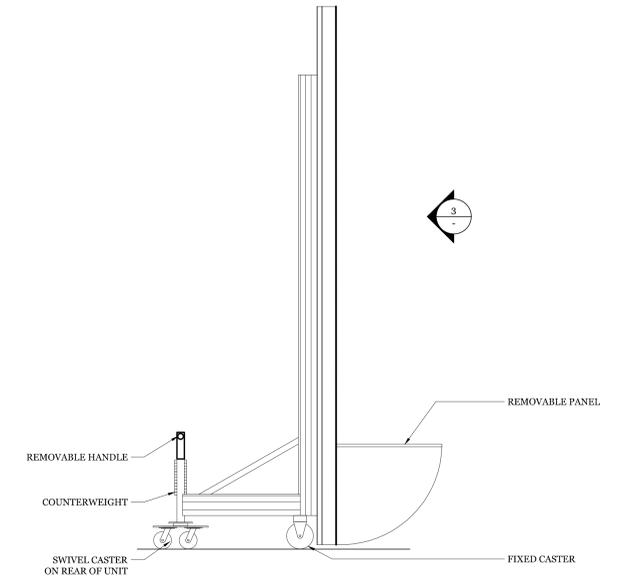


1 ORCHESTRA SHELL TOWER DETAIL SECTION
1/2" = 1'-0"

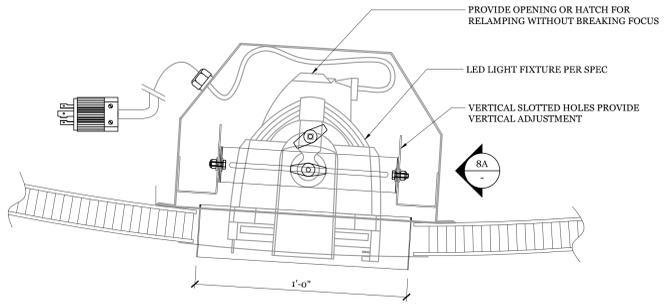

6 LIGHT FIXTURE GIMBAL MOUNT
3" = 1'-0"

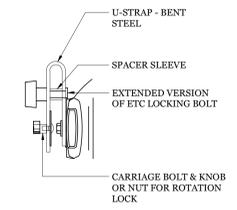

6A TILT/YAW DETAIL
3" = 1'-0"

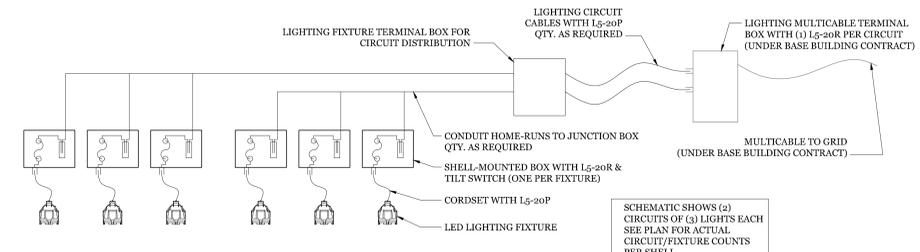

4 LIGHTING WIRING SCHEMATIC
NO SCALE

NO. ISSUE
75% CD CHECK SET

DATE
03/08/2015

SOLANO COMMUNITY COLLEGE
BUILDING 1200 THEATER RENOVATION
4000 SUISUN VALLEY ROAD, FAIRFIELD, CA



ARCHITECT / CONSULTANT
The Shalleck Collaborative Inc.
400 Montgomery St., Suite 500
San Francisco, CA 94104

DSA FILE NO: 48-C1
IDENTIFICATION STAMP
OFFICE OF REGULATION SERVICES
02-113590
AC FLS SS
DATE

APPROVAL

THIS DOCUMENT CONTAINS INFORMATION THAT IS PROPRIETARY TO LPAS, INC. AND IS FURNISHED FOR THE PURPOSES OF REVIEW, BIDDING OR CONSTRUCTION OF THE PROJECT LISTED IN THE JOB TITLE BOX ABOVE AND SHALL NOT BE USED FOR ANY OTHER PURPOSE OR RELEASED TO ANY OTHER PARTY WITHOUT THE WRITTEN CONSENT OF LPAS, INC. INFORMATION CONTAINED HEREIN IS AN INSTRUMENT OF PROFESSIONAL SERVICES AND SHALL REMAIN THE PROPERTY OF LPAS, INC. ALL RIGHTS RESERVED COPYRIGHT © 2014.
THIS DRAWING IS NOT FINAL OR TO BE USED FOR CONSTRUCTION UNTIL IT IS SIGNED BY THE ARCHITECT AND ENGINEER.



SHELL ENCLOSURE DETAILS

SCCD PROJECT NO: 14-014
LPAS PROJECT NO: 764-0002
DATE: JANUARY 19, 2017
SHEET NO:

PO2.01